


Reference images



aluminum cladding
Warm Mid Grey standing seam Aluminum cladding or similar approved



brick cladding
Warm Mid Grey Textured Brick with Light cream Mortar or similar approved

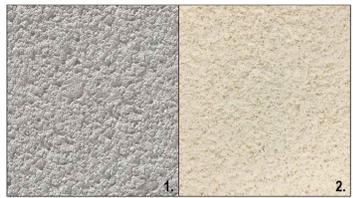

render
1. Light warm grey render or similar approved
2. Cream render or similar approved




solid panels
PPC Aluminium cladding system, Mid Grey colour or similar approved, window frames colour to match

Landscape
for design and details refer to CSR Landscape Drawings




01 Blocks 1 North West Pearse Road Elevation
1:200

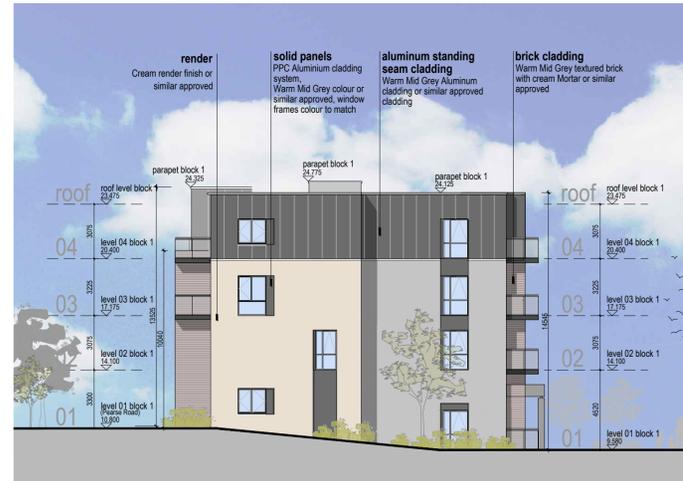


02 Block 1 South West Gable Elevation
1:200



03 Block 1 South East Elevation
1:200

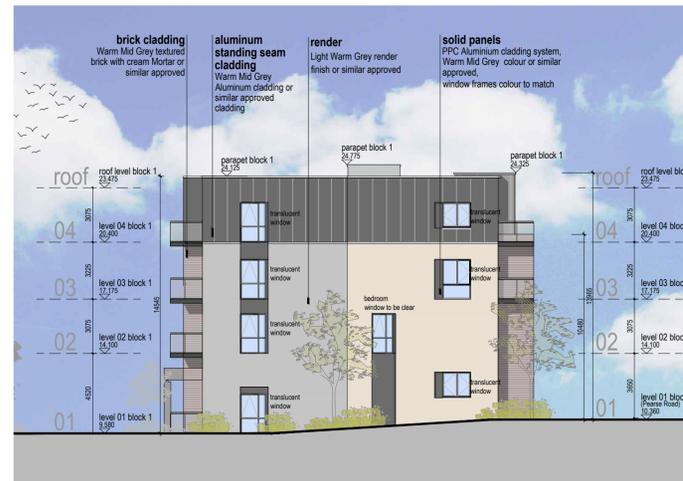

04 Block 1 North East Gable Elevation
1:200

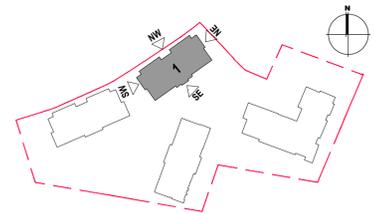

Block 1 Elevations

Notes	Issue Status	No.	Date	Revision	Initials
1. Copyright Reserved	Progress	G	02/04/2023	General update to Elevations	AB
2. Work to figure dimensions only. Do not scale drawing.	Planning Application				
3. The contractor is responsible for checking all levels and dimensions on site and shall refer all discrepancies to the Architect	Fire Cert				
4. Where appropriate, for details of r.c. structure, or mechanical and electrical details, see Engineers drawings	Disability Cert				
5. Proprietary items shall be fixed in strict accordance with manufacturers instructions.	Tender				
6. Sizes of proprietary items shall be checked with manufacturer.	Construction				
7. The contractor shall be responsible for the coordination of structure, finishes and services.	As Built				
	Information Only				

Project									
Kinsale Road LRD									
Drawing Title: Block 1 Elevations									
Stage: Planning	Scale: 1:200@A1	Drawn: AB	Appt: MD	Date: 20/10/23					
Project Code: 6284	job: KRC	origin: BKD	zone: 01	level: ZZ	type: DR	dis: A	sheet no.: 2000	status: P3.4	rev: G

