
 


REFER TO LANDSCAPE ARCHITECTS DRAWING FOR ALL LANDSCAPING DETAILS



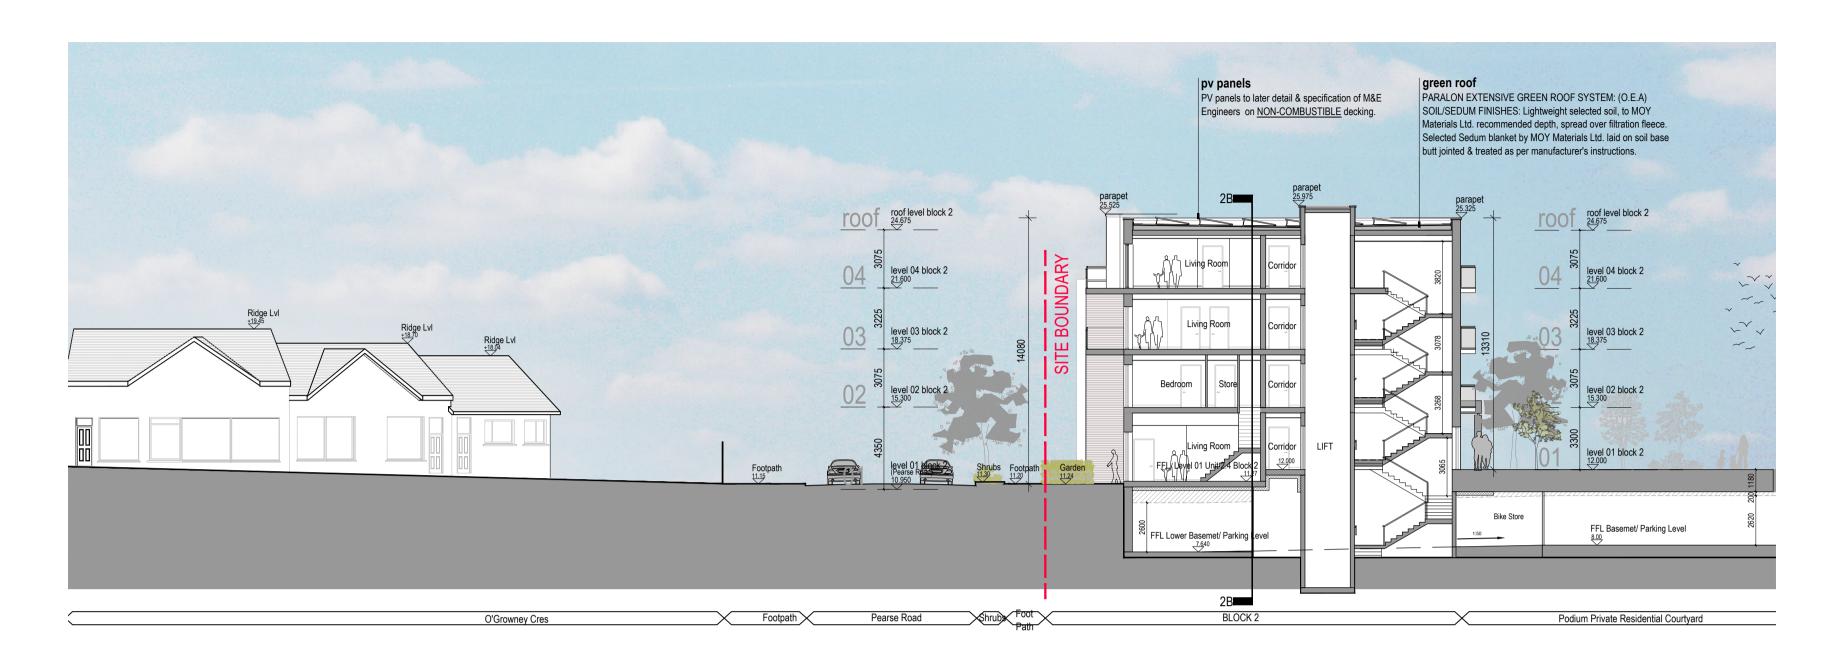



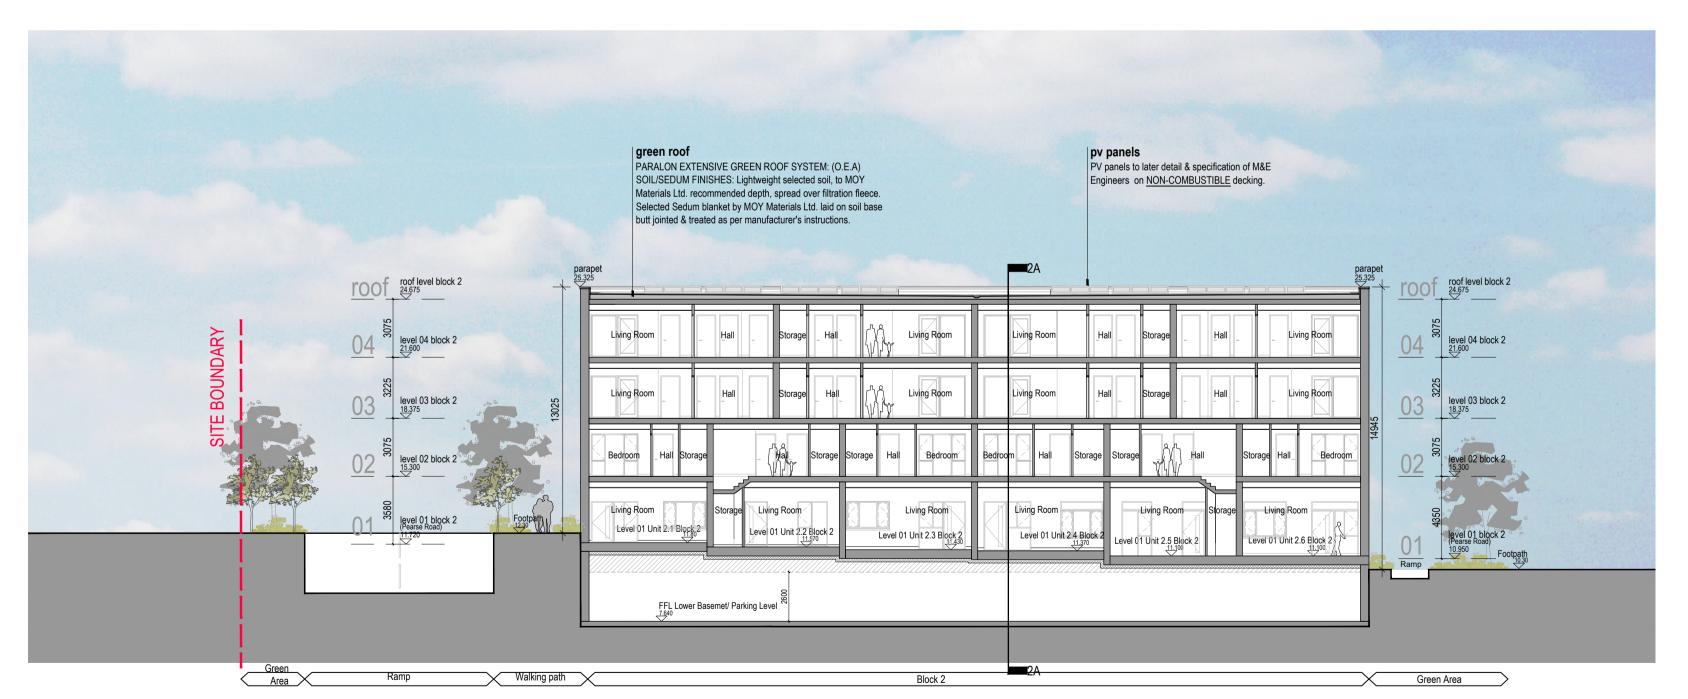

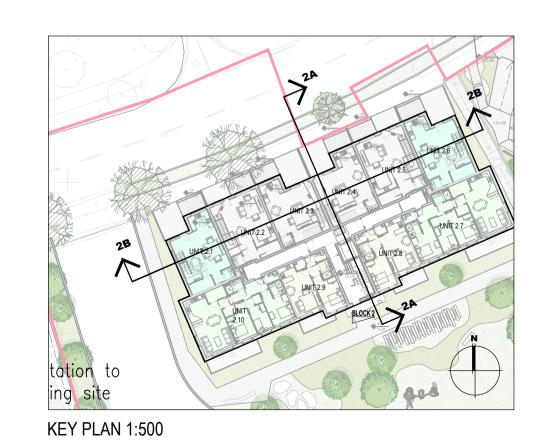

Block 2 Sections

Notes	Issue Status	No. Date Revision Init	ials Project
1. Copyright Reserved 2. Work to figured dimensions only. Do not scale drawing. 3. The contractor is responsible for checking all levels and dimensions on site and shall refer all discrepancies to the Architect 4. Where appropriate, for details of r.c. structure, or mechanical and electrical details, see Engineers drawings 5. Proprietary items shall be fixed in strict accordance with manufacturers instructions. 6. Sizes of proprietary items shall be checked with manufacturer. 7. The contractor shall be responsible for the coordination of structure, finished and consider.	Progress	D 02.04.2025 General Updade to Sections AB	
	Planning Application		
	Fire Cert Disability Cert		
	Disability Cert		Drawing Title
	Tender		
	Construction		Stage
	As Built		Pi
7. The contractor shall be responsible for the coordination of structure, finishes and services.	Information Only		Project Cod
M:\Project Section - Current\6284 Kinsale Road\CAD\Planning\Planning 1\(\frac{1}{2}\) LRD Planning Application\(\frac{2}{2}\) CAD Drawings\(\frac{1}{2}\)	ections)BLOCK 01& 02 SECTIONS KRC-BKD-01-77-DR-A-3000 dwg 04/04/2025 10:25:29		628/

	Kinsale Road LRD				
-	Drawing Title	Block 2 Sections	L La develoite etc		
	Stage Planning	Scale 1:200@A1	Drawn Apd MD	30:08:24	bkd architects
	Project Code 6284	job origin zone KRC - BKD - 02 -	level type dis sheet no. ZZ - DR - A - 3000	status rev P3.4 D	2ND FLOOR EUROPA HOUSE, HARCOURT CENTRE, HARCOURT ST, DUBLIN 02, D02 WR20, IRELAND - EMAIL:ARCHITECTURE@BKD.IE - PH:01 618 2400 - W: WWW.BKD.IE